



1 BALLFIELD CONCESSIONS LIGHTING PLAN
E401 SCALE: 1/4" = 1'-0"

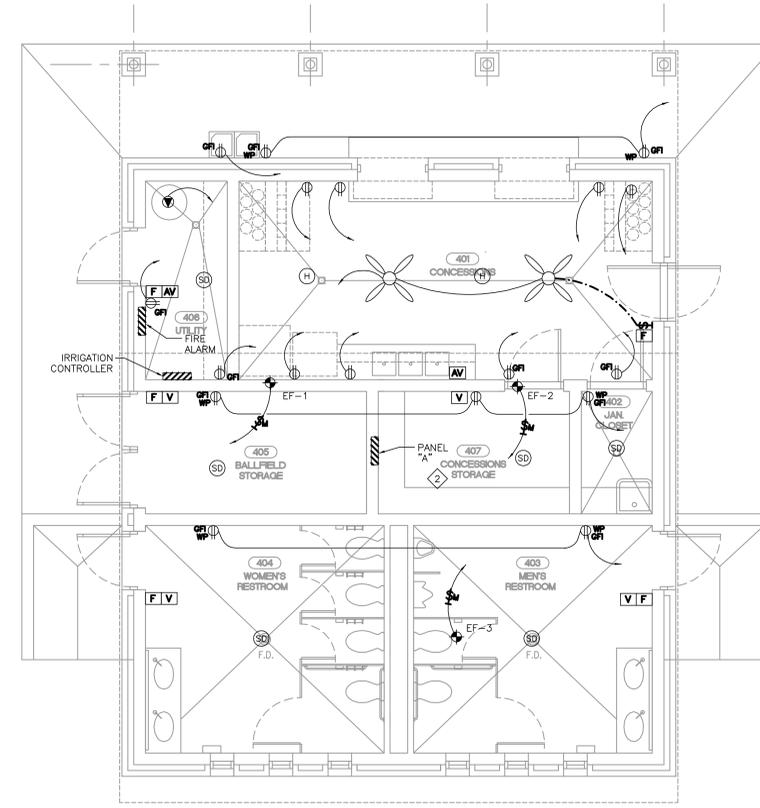

2 BALLFIELD CONCESSIONS POWER PLAN
E401 SCALE: 1/4" = 1'-0"

- KEYED NOTES: (THIS SHEET ONLY)
- ① CONTRACTOR SHALL CONTROL THESE FIXTURES VIA PHOTOCELL WITH MANUAL OVERRIDE SWITCH (HAND, OFF AUTO) LOCATED IN THE ELECTRICAL ROOM.
 - ② CONTRACTOR SHALL PROVIDE, INSTALL, AND CONNECT COMPLETE CLASS A FIRE ALARM SYSTEM TO MEET ALL LOCAL AND BASE CODES.

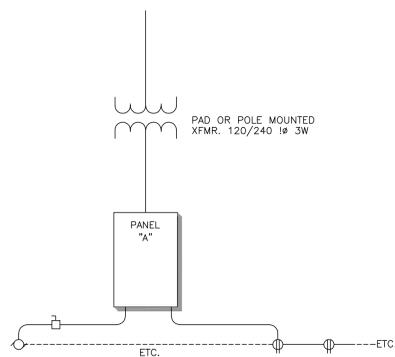

3 ONE-LINE DIAGRAM
E401 N.T.S.

LIGHTING FIXTURE SCHEDULE							
MARK	MANUFACTURER & CATALOG NUMBER	# LAMPS	MOUNTING	FIXTURE VA	LAMP DATA	VOLTAGE	NOTES
A2	LITHONIA # 2SP-X-2-32-A12-X-GEB10	2	*	90	F32/T8	*	STATIC TROUFER MOUNTING AND VOLTAGE AS REQUIRED.
A3	LITHONIA # 2SP-X-3-32-A12-X-GEB10	3	*	120	F32/T8	*	STATIC TROUFER MOUNTING AND VOLTAGE AS REQUIRED.
A4	LITHONIA # 2SP-X-4-32-A12-X-GEB10	4	*	160	F32/T8	*	STATIC TROUFER MOUNTING AND VOLTAGE AS REQUIRED.
D1	LITHONIA # DM-2-48HO-X-GEB10	2	SURFACE	110	F48 / HO	*	ENCLOSED AND GASKETED INDUSTRIAL VOLTAGE AS REQUIRED.
DW1	LITHONIA # DMW-2-48HO-X-GEB10	2	SURFACE	110	F48 / HO	*	ENCLOSED AND GASKETED INDUSTRIAL VOLTAGE AS REQUIRED, LISTED FOR WET LOCATION.
G1	LITHONIA # C-2-32-X-GEB10-WGCUN	2	SURFACE	90	F32/T8	*	GENERAL PURPOSE STRIP VOLTAGE AS REQUIRED.
W1	LITHONIA # TWM-250S-TB	1	WALL	300	HPS 250W	*	HIGH PRESSURE SODIUM WALL-PAK WITH MULTI-TAP BALLAST.
X1	LITHONIA # LRP-B-X-CC-X-120/277-ELN-X	N/A	*	2	LED	120/277	EDGE-LIT EXIT WITH FACES, DIRECTIONAL INDICATOR AND MOUNTING AS REQUIRED.

SYMBOL	DESCRIPTION	DATE	APPROVAL
REVISIONS			
Drawn by: G. CRAWL COORDINATION: Engr: Design and Construction:		HEADQUARTERS AIR FORCE SERVICES AGENCY Title: UNITED STATES AIR FORCE NON-APPROPRIATED FUNDS PROJECT 35% AFNAF PROTOTYPES DESIGN CONTRACT NO. NAFF198C0002 BALLFIELD CONCESSION STAND - LIGHTING AND POWER PLAN	
APPROVAL: Director of Facilities date Director of Operations date		SCALE: 1/4" = 1'-0" DATE: APRIL 7, 2000	SHEET E401 OF