

PLUMBING FIXTURE SCHEDULE							
MARK	DESCRIPTION	WASTE	VENT	TRAP	WATER		NOTES
					COLD	HOT	
P-1A	WATER CLOSET	4"	2"	---	1"	---	WALL-HUNG, VITREOUS CHINA, OPEN-FRONT SEAT LESS COVER, 1.6 GALLONS PER FLUSH, FLUSH VALVE, WHITE.
P-1B	WATER CLOSET (ADA)	4"	2"	---	1"	---	WALL-HUNG, VITREOUS CHINA, OPEN-FRONT SEAT LESS CVR 1.6 GAL. PER FLUSH, ADA COMPLIANT FLUSH VALVE, WHITE.
P-2A	URINAL (ADA)	2"	1-1/2"	---	3/4"	---	WALL-HUNG, VITREOUS CHINA, ADA COMPLIANT, 1.0 GAL.-PER-FLUSH; FLUSH VALVE, WHITE.
P-3A	LAVATORY (ADA)	2"	1-1/2"	---	1/2"	---	20"x17"; HOT/COLD WATER SUPPLIES, ADA-COMPLIANT, SELF CLOSING FAUCET, COORDINATE TYPE OF LAVATORY WITH ARCH.
P-4A	SHOWER (ADA)	2"	1-1/2"	2"	1/2"	1/2"	ADA-COMPLIANT CONTROLS, HAND-HELD SHOWER HEAD, THERMO-STATIC MIXING VALVE, HEAVY-DUTY (EQUAL TO ACORN, BRADLEY), 1.0 SHOWER FLOW CONTROL, COORDINATE ENCLOSURE, FLOOR DRAIN, SEAT, GRAB BARS, ETC. WITH ARCHITECT.
P-4B	SHOWER (ADA)	2"	1-1/2"	2"	1/2"	1/2"	
P-5A	SINK (ADA)	2"	1-1/2"	1-1/2"	1/2"	1/2"	STAINLESS STEEL, TWO COMPARTMENT SINK-33"x22"x6" DEEP.
P-6A	WATER COOLER (ADA)	2"	1-1/2"	1-1/2"	1/2"	---	TWO LEVEL, ADA COMPLIANT, STAINLESS STEEL, SINGLE COMPRESSOR (DRAINABLE IN FREEZING CLIMATES).

NOTE: THE FLUSH VALVE HANDLE TO HANDICAPPED-USE WATER CLOSETS SHALL BE LOCATED ON THE "WIDE" SIDE OF THE STALL.

**PLUMBING SPECIFICATIONS**

ALL WORK SHALL COMPLY WITH PROVISIONS OF THE LATEST EDITION UNIFORM PLUMBING CODE THE LATEST EDITION OF THE UNIFORM FIRE CODE AND ALL OTHER CODES AND REGULATIONS SET FORTH BY THE AUTHORITY(IES) HAVING JURISDICTION.

CONTRACTOR SHALL PAY FOR ALL PERMITS, FEES, LICENSES, ETC. REQUIRED FOR HIS WORK.

THERE SHALL BE A ONE-YEAR GUARANTEE ON ALL WORK.

THE DRAWINGS DO NOT SHOW ALL DETAILS, FITTINGS, EXACT LOCATION OF PIPES, ETC. IT IS LEFT TO THE DESIGNER TO PROVIDE THE NECESSARY ITEMS IN AN APPROPRIATE MANNER TO RESULT IN PROPERLY FUNCTIONING SYSTEMS.

IF THE CONTRACTOR WANTS TO PROVIDE EQUIPMENT OF DIFFERENT TYPE OR MANUFACTURE THAN THAT CALLED OUT ON THESE PLANS, HE SHALL FIRST SUBMIT THOSE ITEMS TO THE CONTRACTING OFFICER FOR APPROVAL.

ALL WORK SHALL BE RUN CONCEALED UNLESS OTHERWISE NOTED.

CONTRACTOR SHALL REPAIR AND/OR PATCH ALL OPENINGS OR DEFECTS DUE TO INSTALLATION OF HIS WORK.

ALL MATERIALS SHALL BE NEW AND OF THE QUALITY INDICATED. WATER LINES SHALL BE COPPER TYPE L. WASTE AND VENT LINES SHALL BE CAST IRON (HUBLESS ABOVE-GROUND, HUB AND SPIGOT UNDERGROUND), GAS PIPING TO BE SCH. 40 BLACK STEEL.

INSULATE ALL HOT WATER LINES WITH 1-INCH FIBERGLASS (OWENS CORNING OR KNAUF) WITH ALL SERVICE JACKET.

CONTRACTOR SHALL PROVIDE RECORD DRAWINGS, CONSISTING OF MARKED-UP BLUE-LINE COPY.

ALL WATER (HOT AND COLD) PIPING SHALL BE PRESSURE TESTED AND STERILIZED; ALL GAS PIPING TO BE PRESSURE TESTED.


ALL PLUMBING CONTRACTORS MUST BE QUALIFIED AND LICENSED.

PROVIDE A SLEEVE FOR SPACING AROUND ALL PIPING WHICH PENETRATES THROUGH FOUNDATION SLAB/BEAMS TO ALLOW FOR MOVEMENT. SEAL ALL SPACING AROUND PIPES WITH WOOL MATERIAL AND CAULK.

ALL VENT AND OTHER PENETRATIONS THROUGH THE ROOF ARE TO BE FLASHED IN.

WHEN WATER LINES ARE INSTALLED ON THE EXTERIOR WALL, THE WALL INSULATION SHALL BE BETWEEN THE PIPE AND THE EXTERIOR WALL.

INSTALL SANITARY SEWER AT 2% SLOPE MINIMUM.

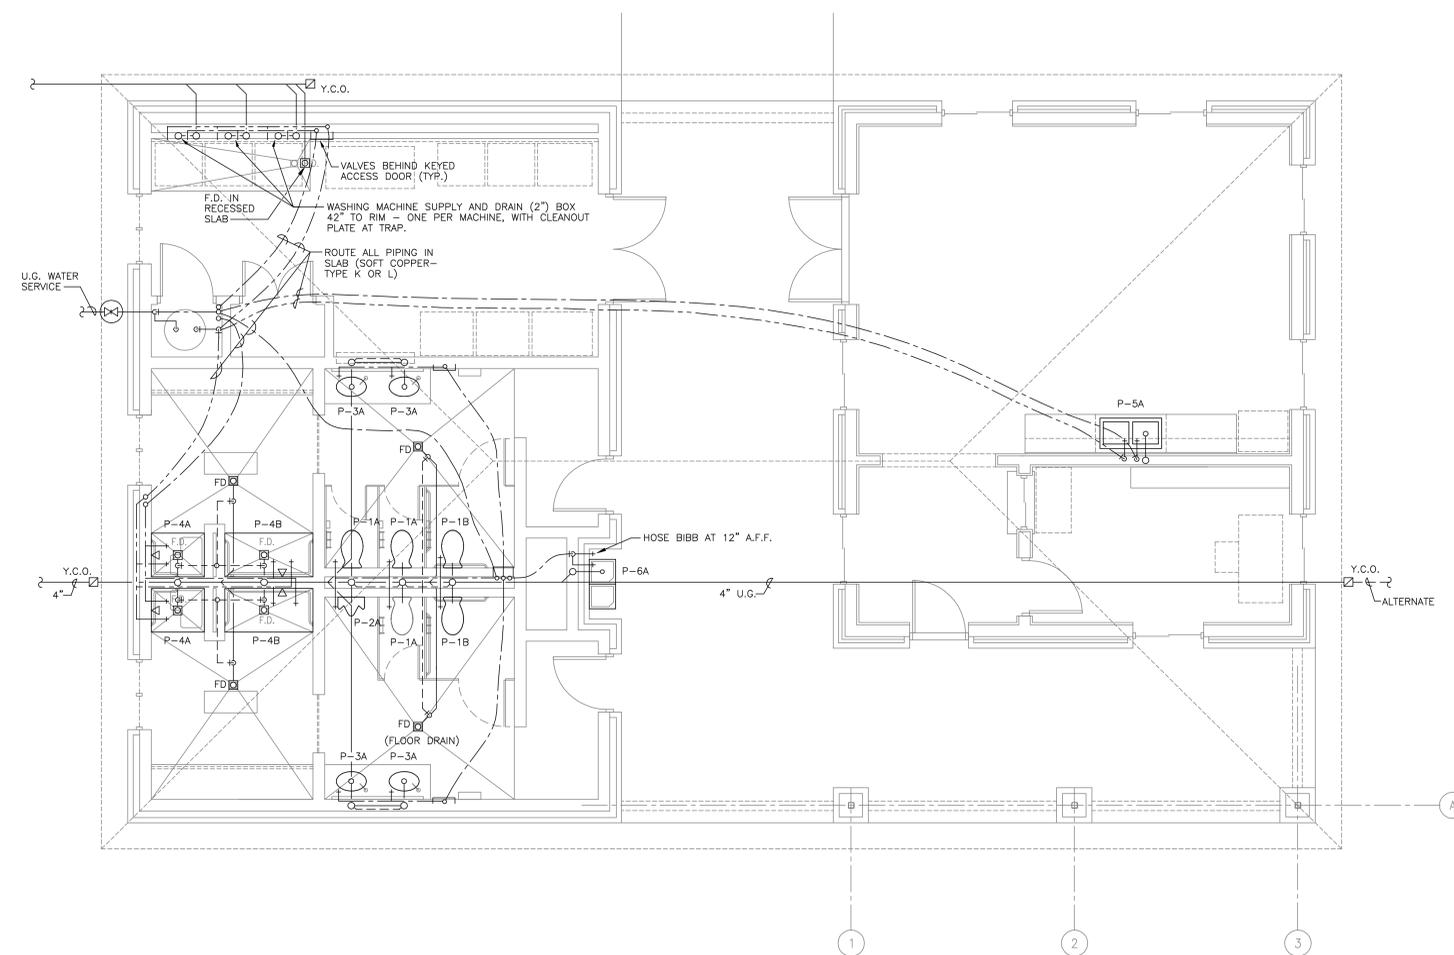

1 FAMCAMP SERVICE FACILITY - FLOOR PLAN  
 SCALE: 1/4" = 1'-0"  
 PLAN NORTH

SYMBOL	DESCRIPTION	DATE	APPROVAL
REVISIONS			
Drawn by: R.R.G.		HEADQUARTERS AIR FORCE SERVICES AGENCY	
COORDINATION:		Title:	
Engr:		NON-APPROPRIATED FUNDS PROJECT	
Design and Construction:		35% AFNAF PROTOTYPES DESIGN	
APPROVAL:		CONTRACT NO. NAFB195C00012	
Director of Facilities		FAMCAMP SERVICE FACILITY	
Director of Operations		PLUMBING FLOOR PLAN	
SCALE: 1/4"=1'-0"	DATE: APRIL 17, 2000	SHEET	P2.01
DRAWING NUMBER:		OF	